




Memorandum


Project: **Nebraska Workers' Compensation Court Judges Office**
Project Number: 155-164-14
To: Prospective Bidders
Attention:
From: The Clark Enersen Partners
Date: 3/4/2014
Subject: **Missing Supplemental Drawing**

Please find attached SDM-001 it was inadvertently omitted from Addendum No. 1.

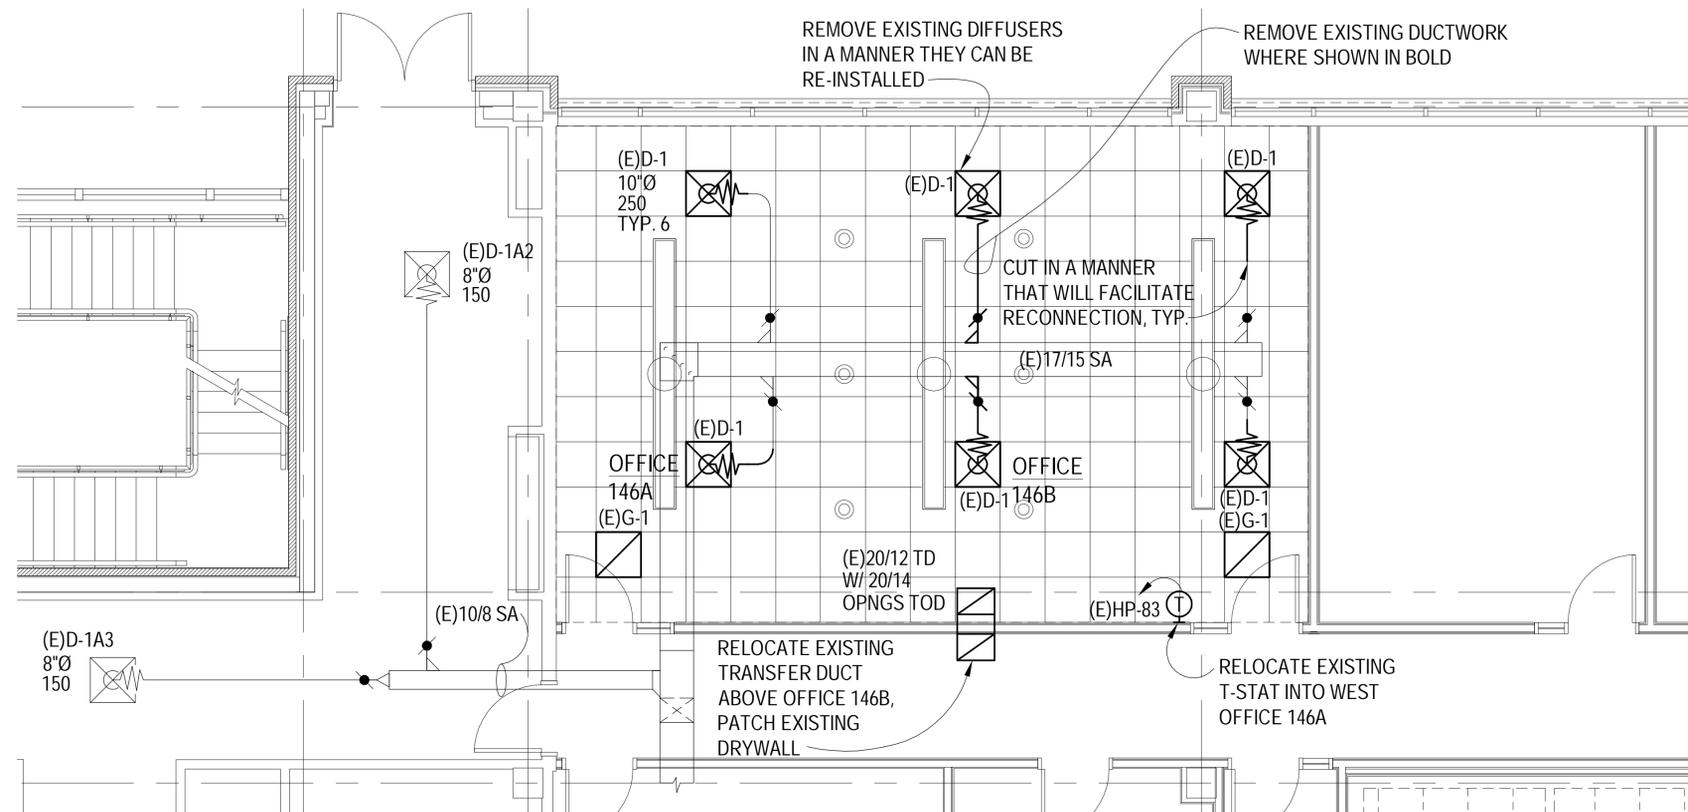

PARTIAL FIRST FLOOR DEMOLITION PLAN

SCALE: 1/8"=1'-0"

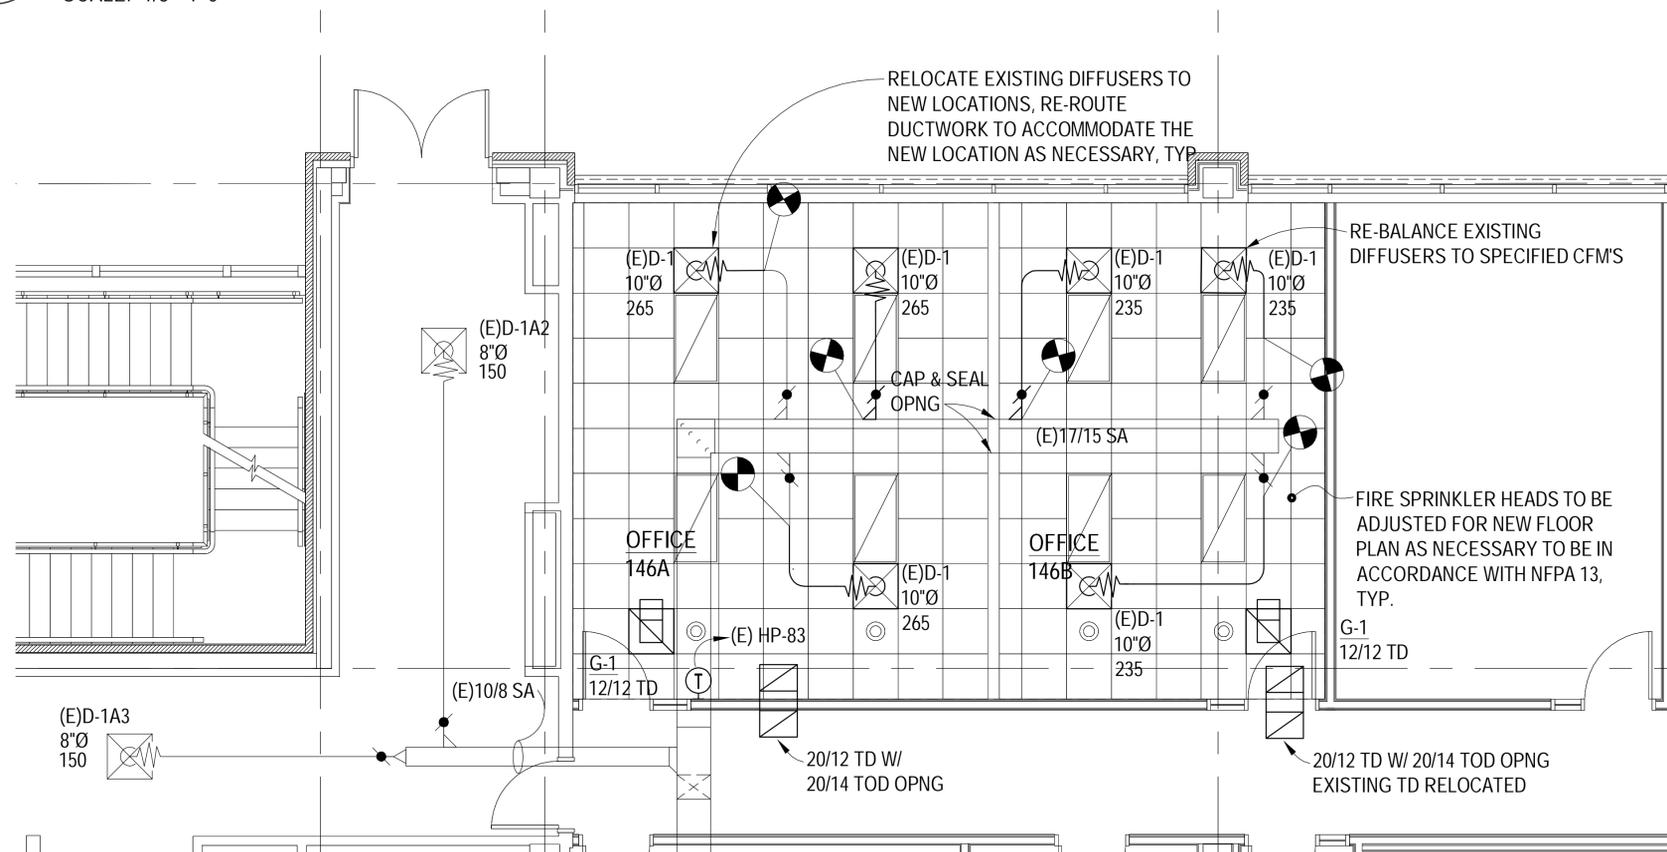

PARTIAL FIRST FLOOR HVAC PLAN

SCALE: 1/8"=1'-0"